



空気弁室構造図 S=1:30


平面図

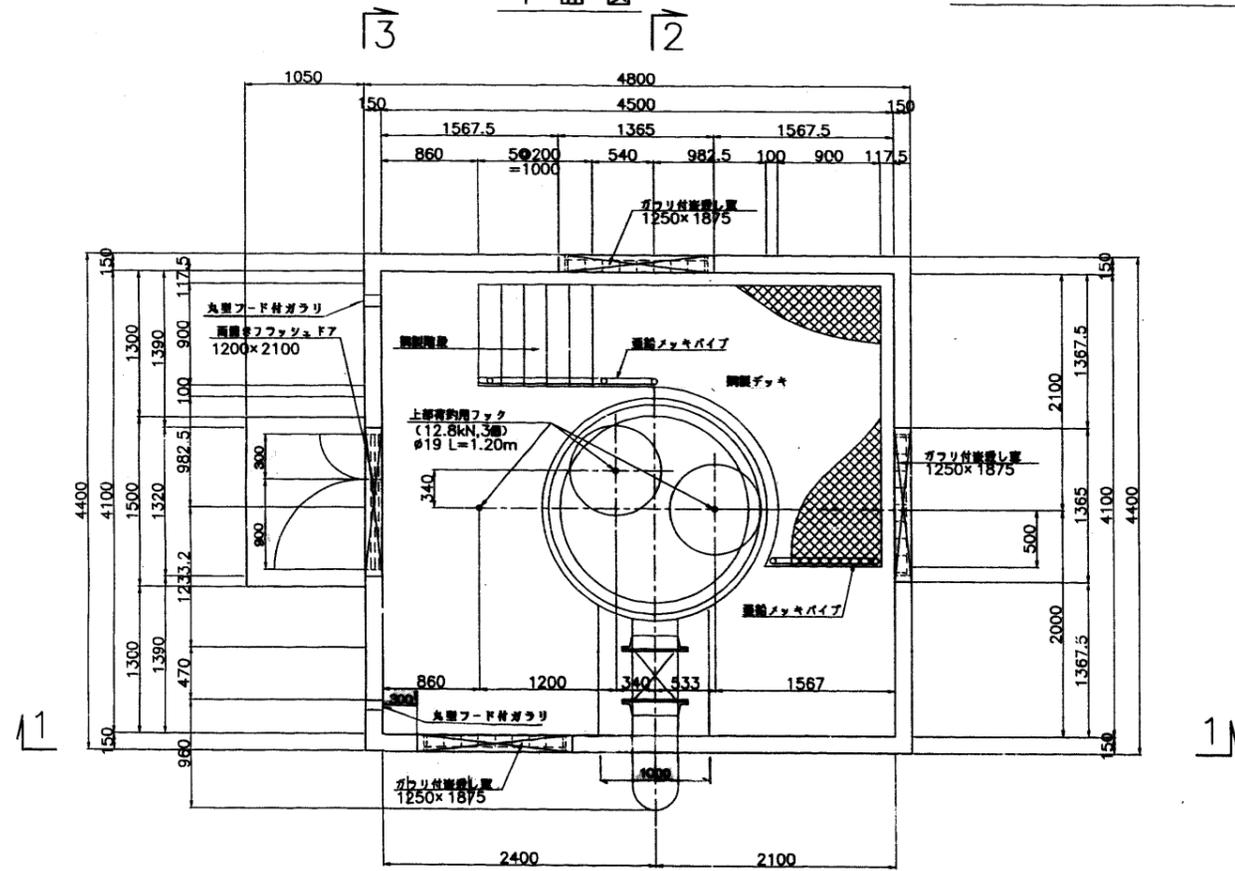


1-1

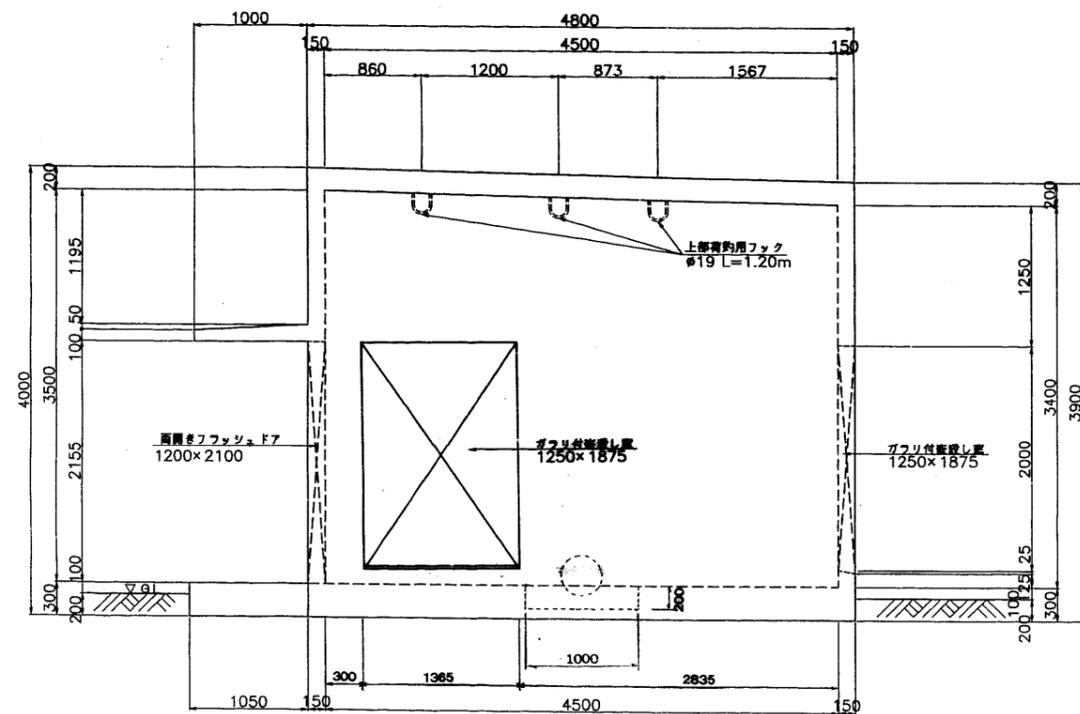


2-2

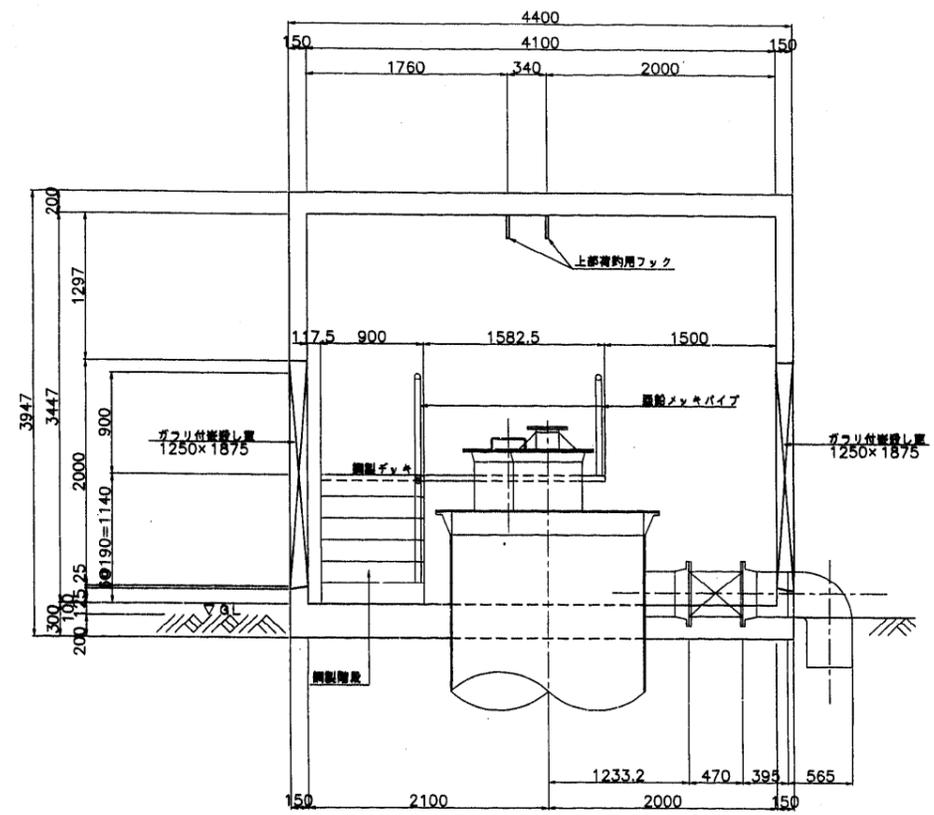


3-3

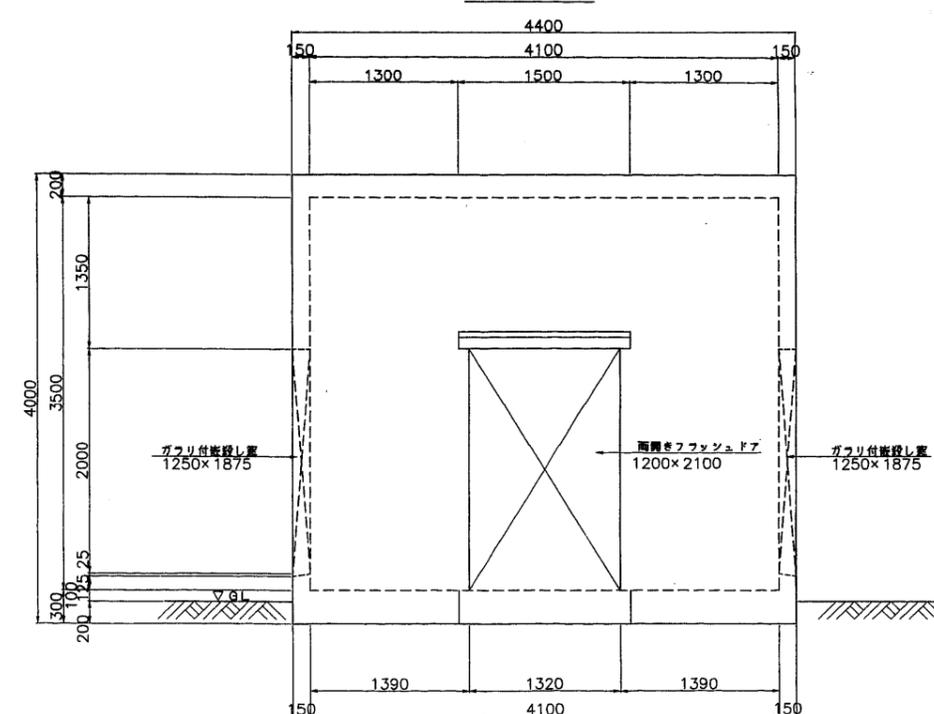

排泥部平面図

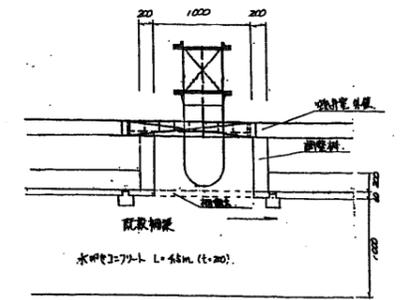

排泥部断面図

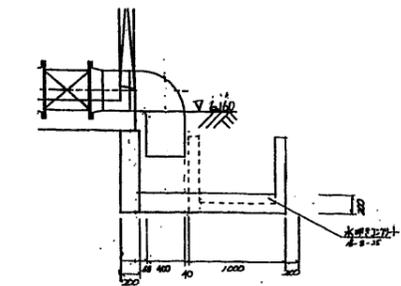


施設名	南部幹線用水路 (0312100-1100-20)		
図面名	8号排泥工 (2/3)		
作成年月	平成26年 3月		
縮尺	A1 1:30 A2 1:42	図面番号	8-200/310
作成者	関東農政局 両総農業水利事業所		

8号排泥工 (3/3)


No. 207+2.754

鋼製デッキ構造図 S=1:20


平面図

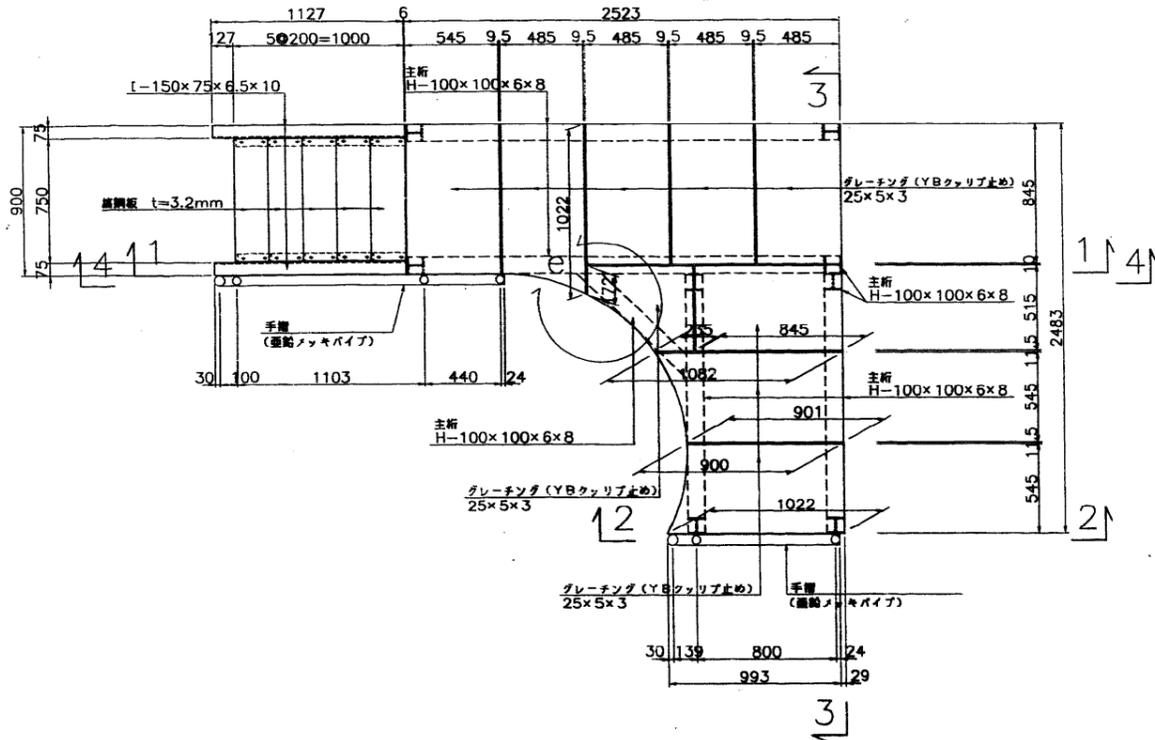


3-3

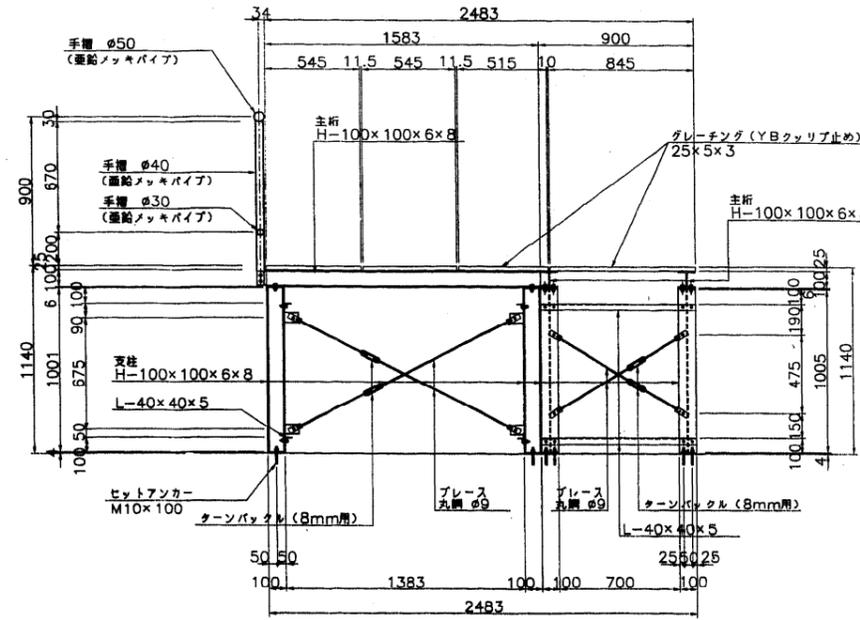


2-2

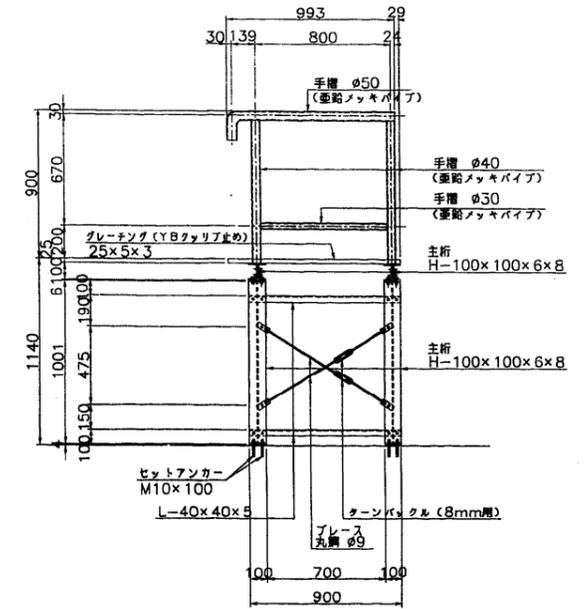


1-1

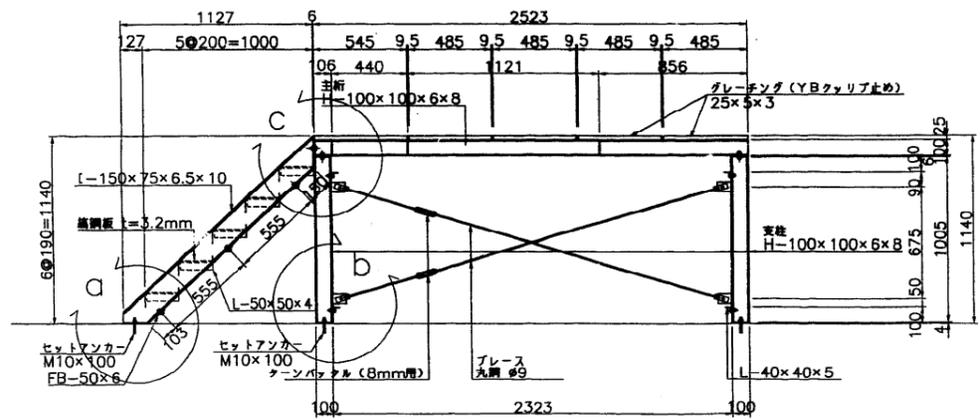

4-4

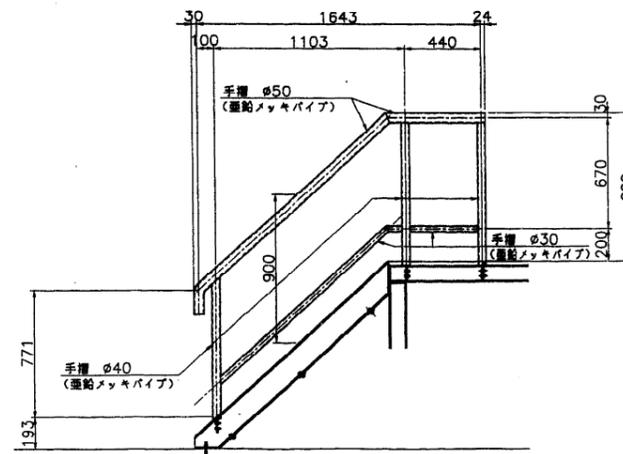


f 部詳細 s=1:10

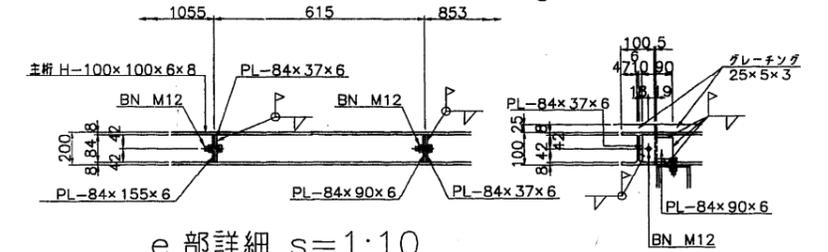


g 部詳細 s=1:10


e 部詳細 s=1:10

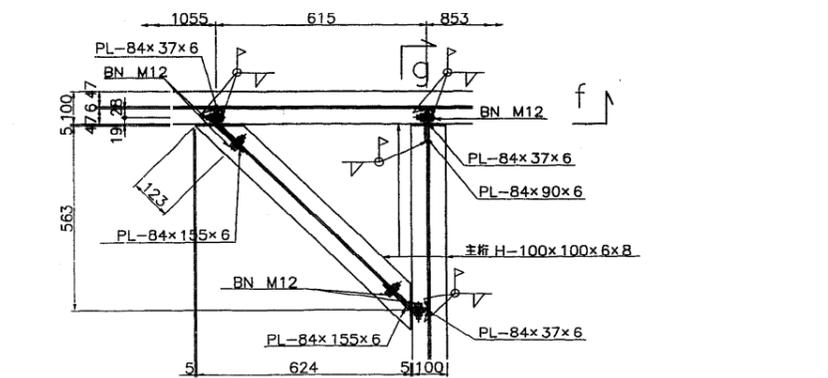


a 部詳細 s=1:5

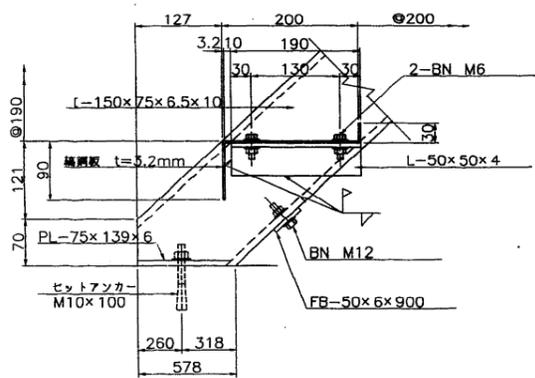


b 部詳細 s=1:5

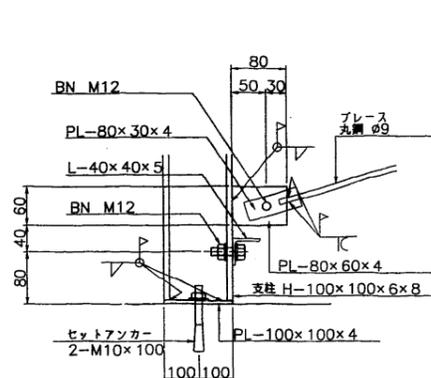

c 部詳細 s=1:5

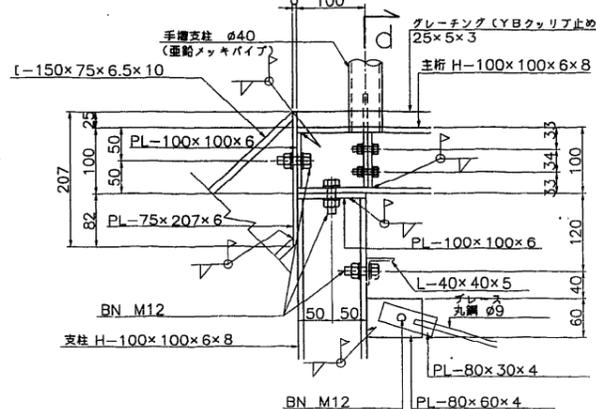

d 部詳細 s=1:5

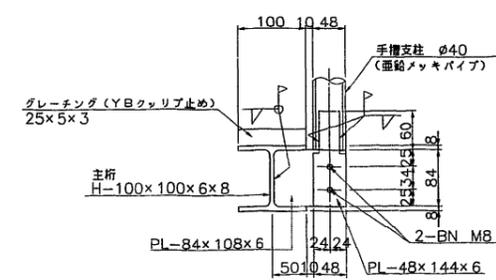

施設名	南部幹線用水路 (0312100-1100-20)		
図面名	8号排泥工 (3/3)		
作成年月	平成26年 3月		
縮尺	A1 図示	図面番号	8-201/310
作成者	関東農政局 商総農業水利事業所		