



1号減圧工・39号空気弁工 (1/2)

No. 9+1. 5244


床版平面図 S=1:50

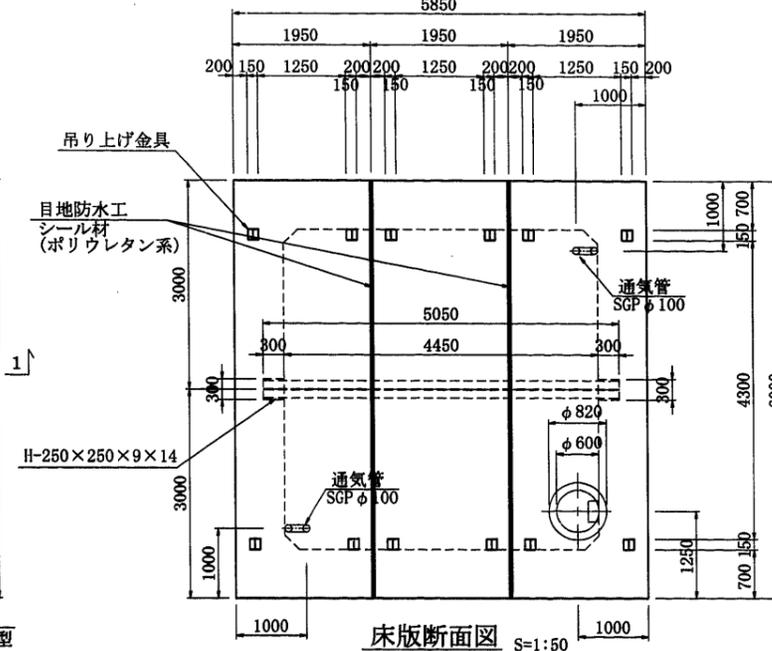


床版断面図 S=1:50

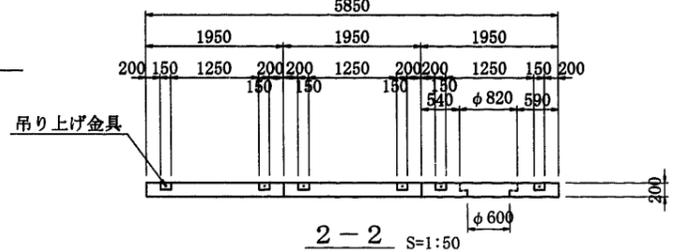


平面図 S=1:50

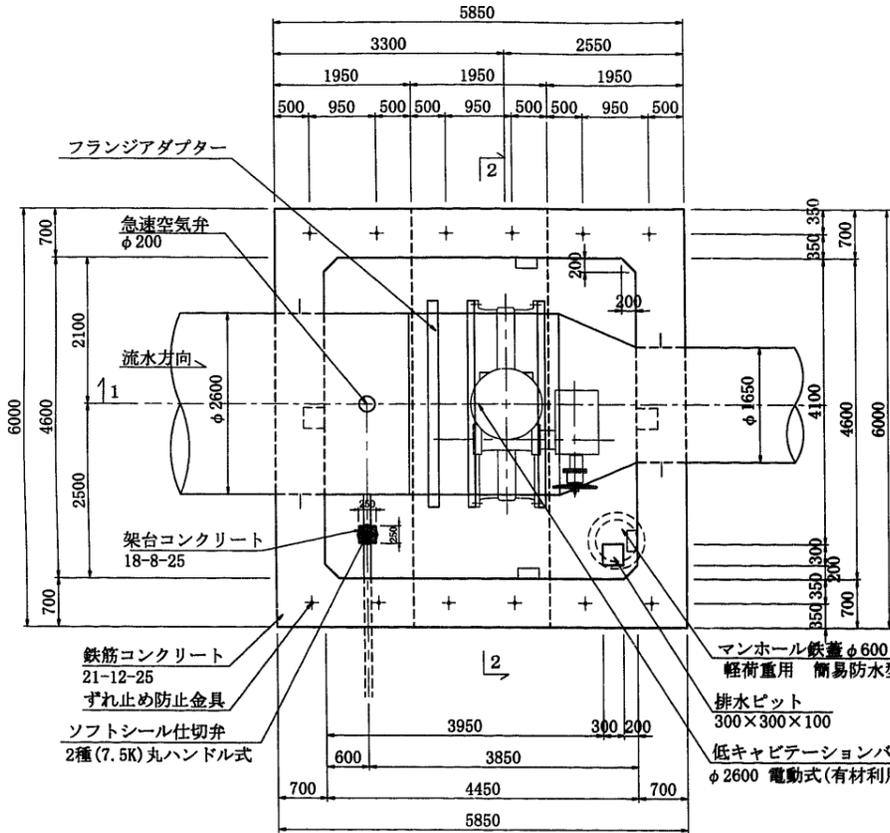


1-1 S=1:50

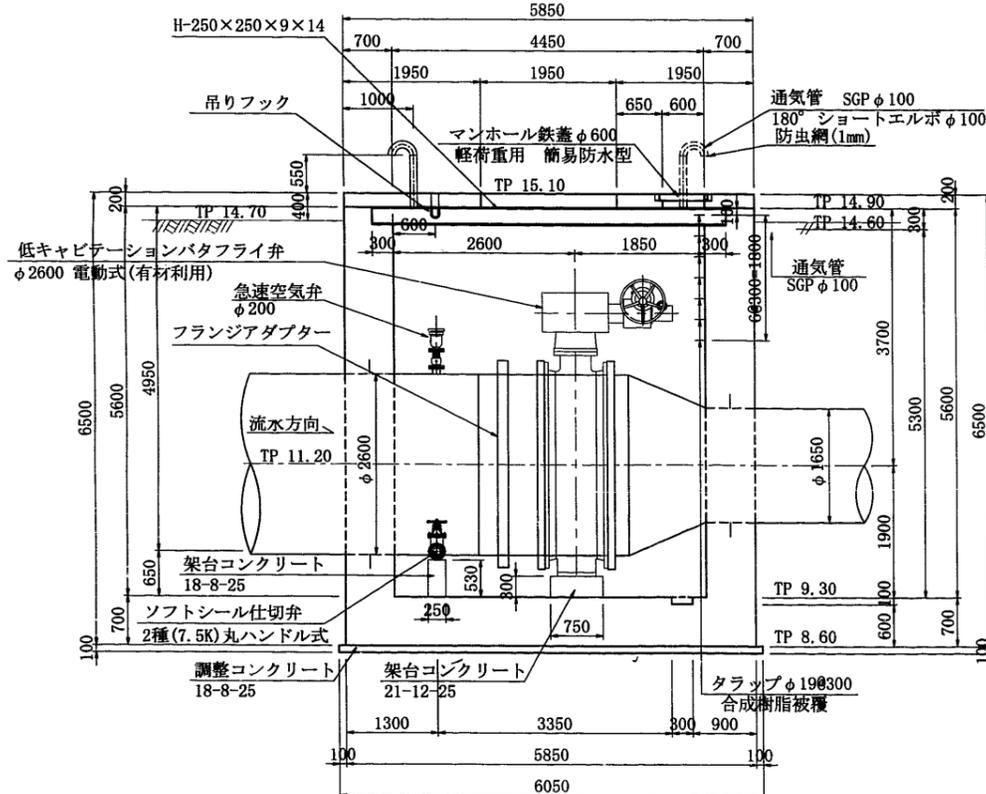



ずれ止め工詳細図 S=1:20

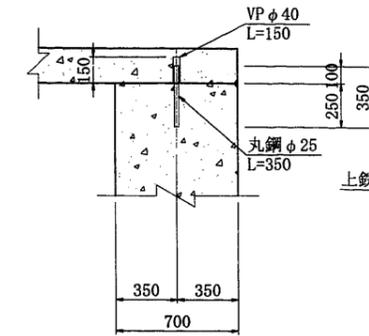


吊りフック詳細図 S=1:20

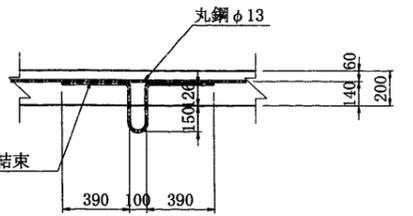


目地防水工詳細図 S=1:20

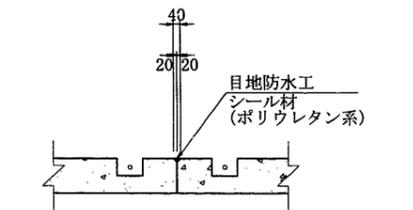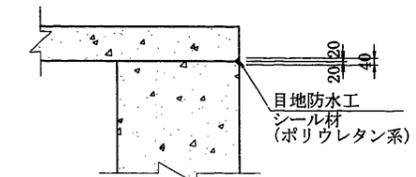



吊り上げ金具詳細図 S=1:20

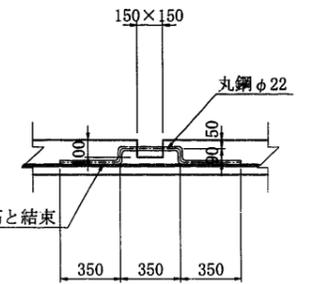


水抜工詳細図 S=1:20

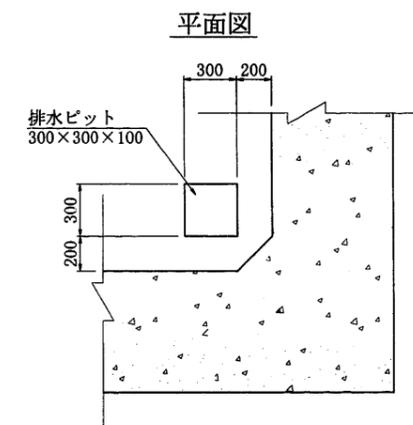


タラップ詳細図 S=1:20

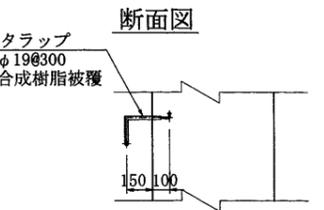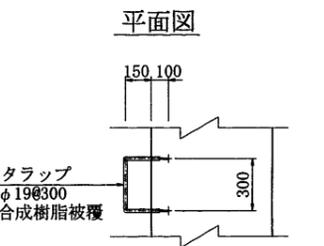

ずれ止め防止金具

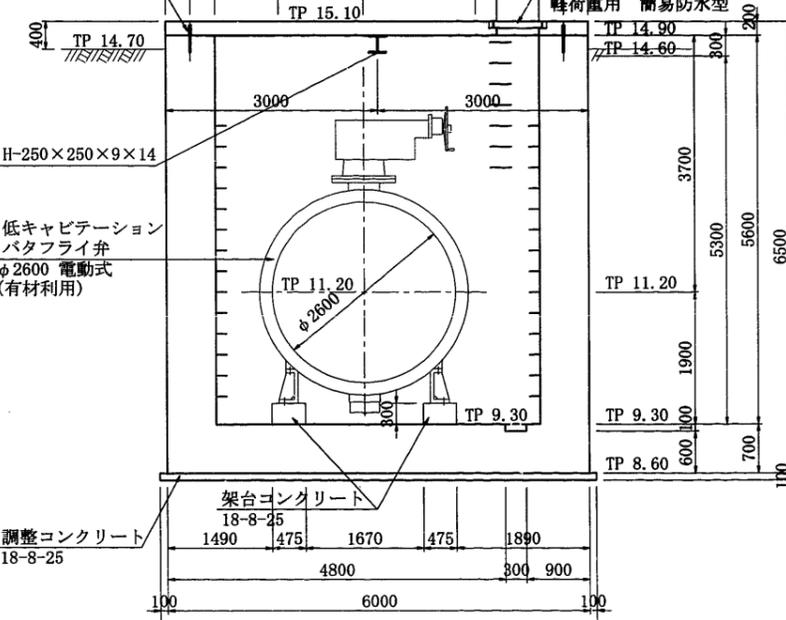

断面図

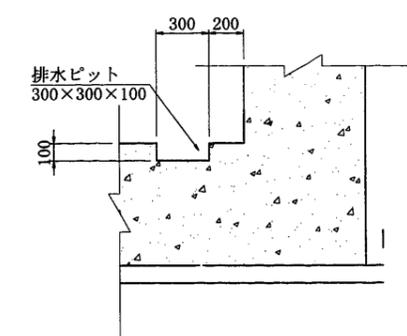


施設名	南部幹線水路(0312100-1100-20)
図面名	1号減圧工・39号空気弁工 (1/2)
作成年月	平成26年 3月
縮尺	A1 図示 図面番号 8-217/310
作成者	関東農政局 両総農業水利事業所

1号減圧工・39号空気弁工 (2/2)


No. 9+1. 5244

渡り梯子詳細図 S=1:30


側面図

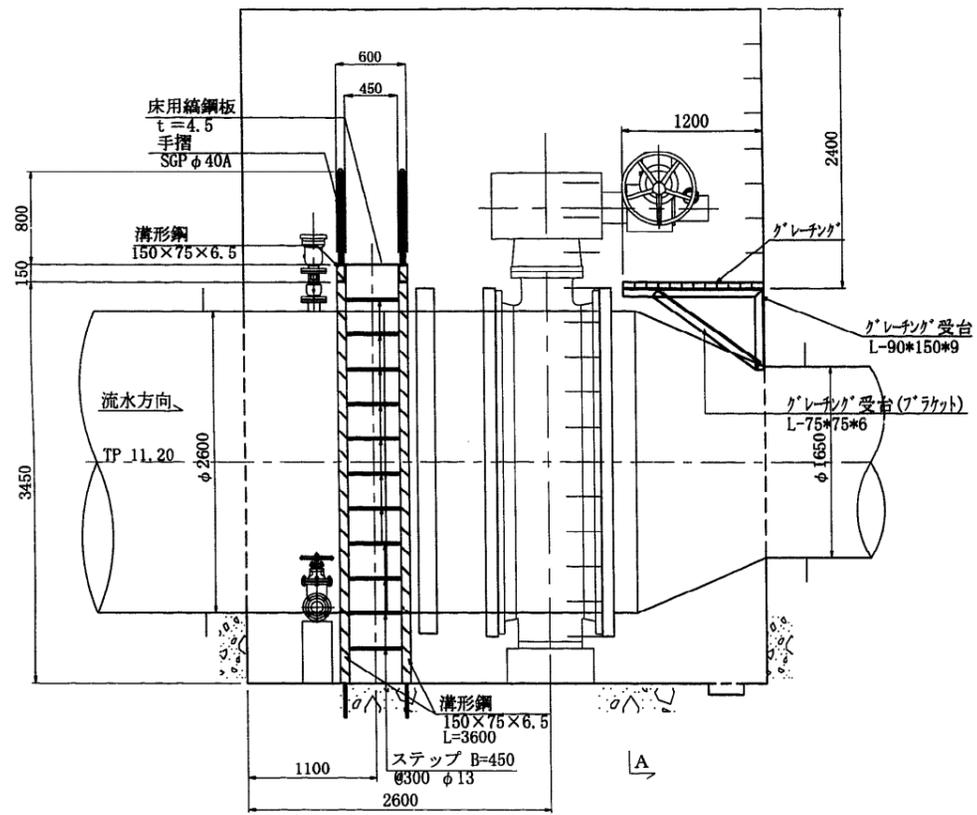


断面図

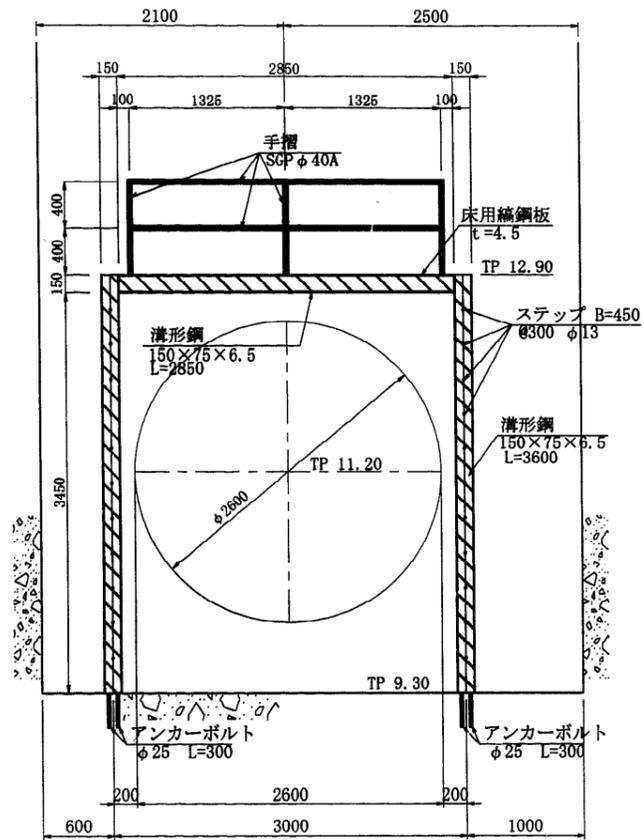


A - A

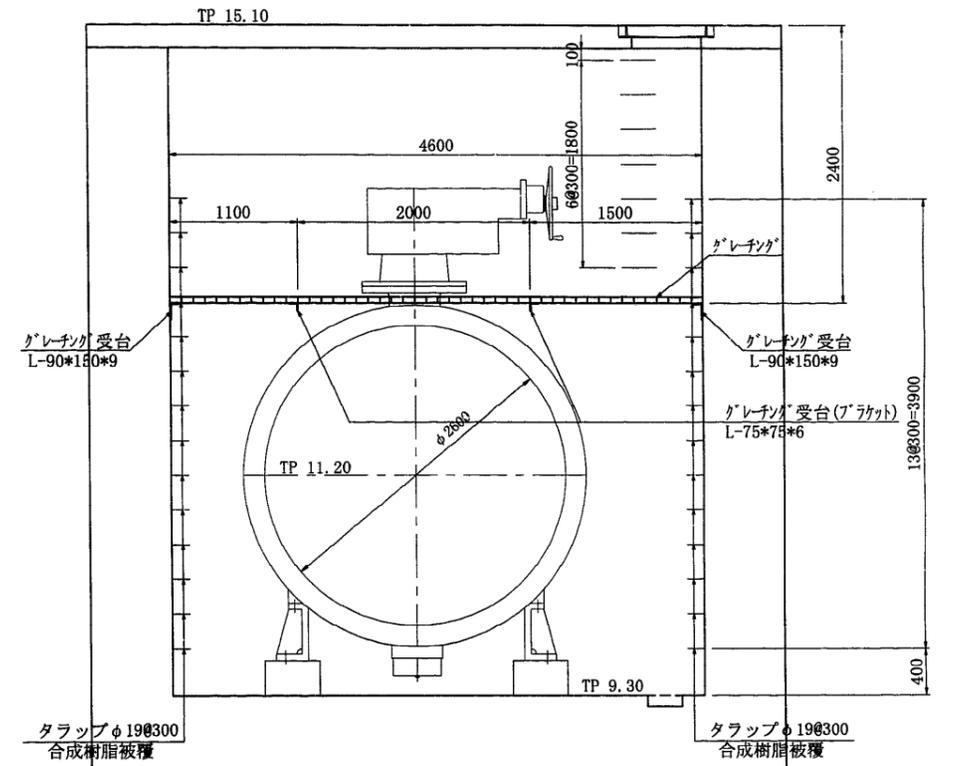


平面図

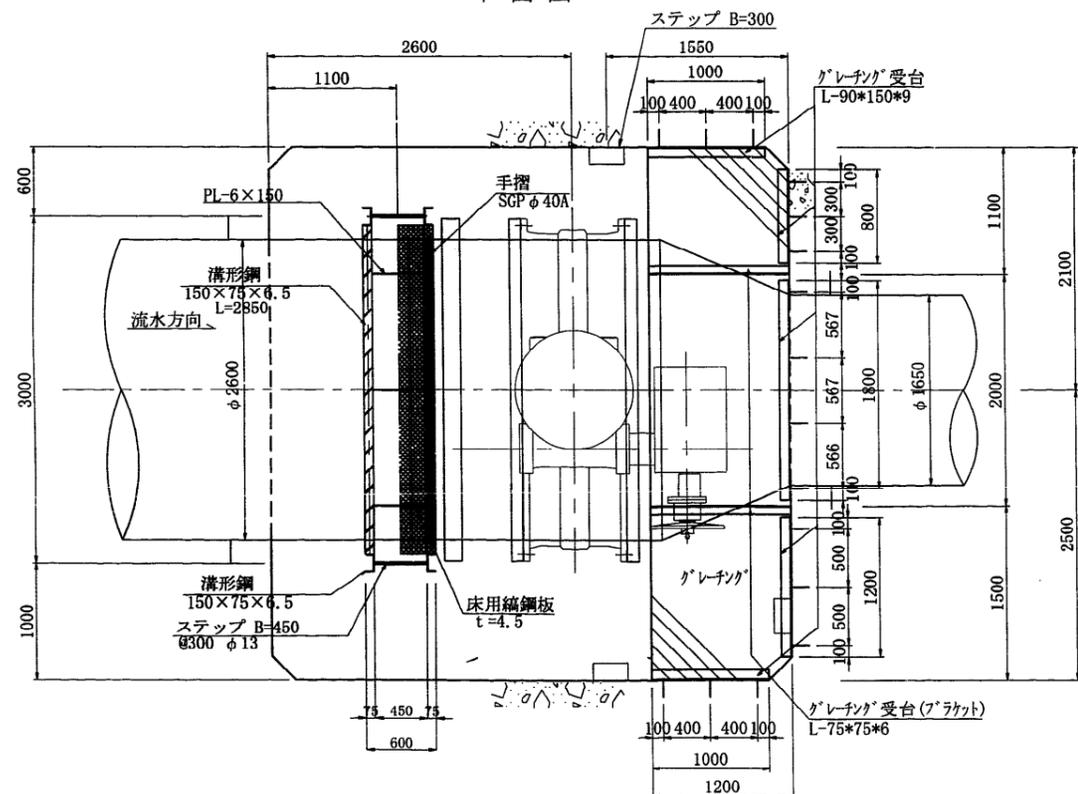


アンカー取付詳細図 S=1:10

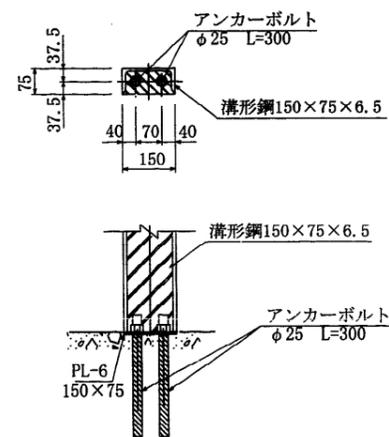

ブラケット S=1:10

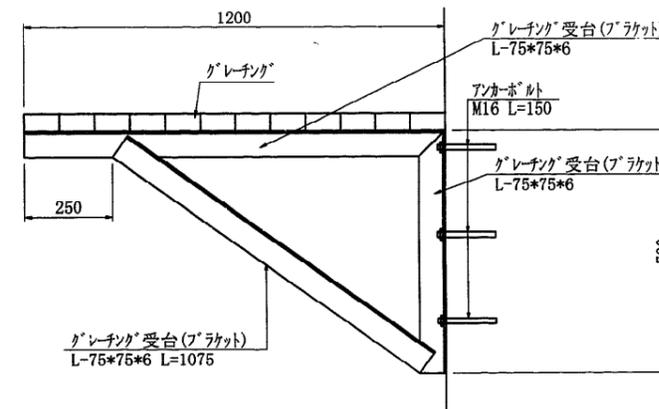

グレーチング受台 S=1:10

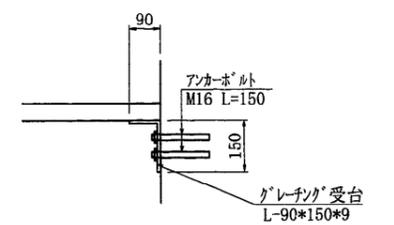

施設名	南部幹線用水路 (0312100-1100-20)		
図面名	1号減圧工・39号空気弁工 (2/2)		
作成年月	平成26年 3月		
縮尺	A1 図示	図面番号	8-218/310
作成者	関東農政局 両総農業水利事業所		