


1号制水弁工・9号空気弁工 (1/2)


S=1:50

No. 31+49. 915


平面図

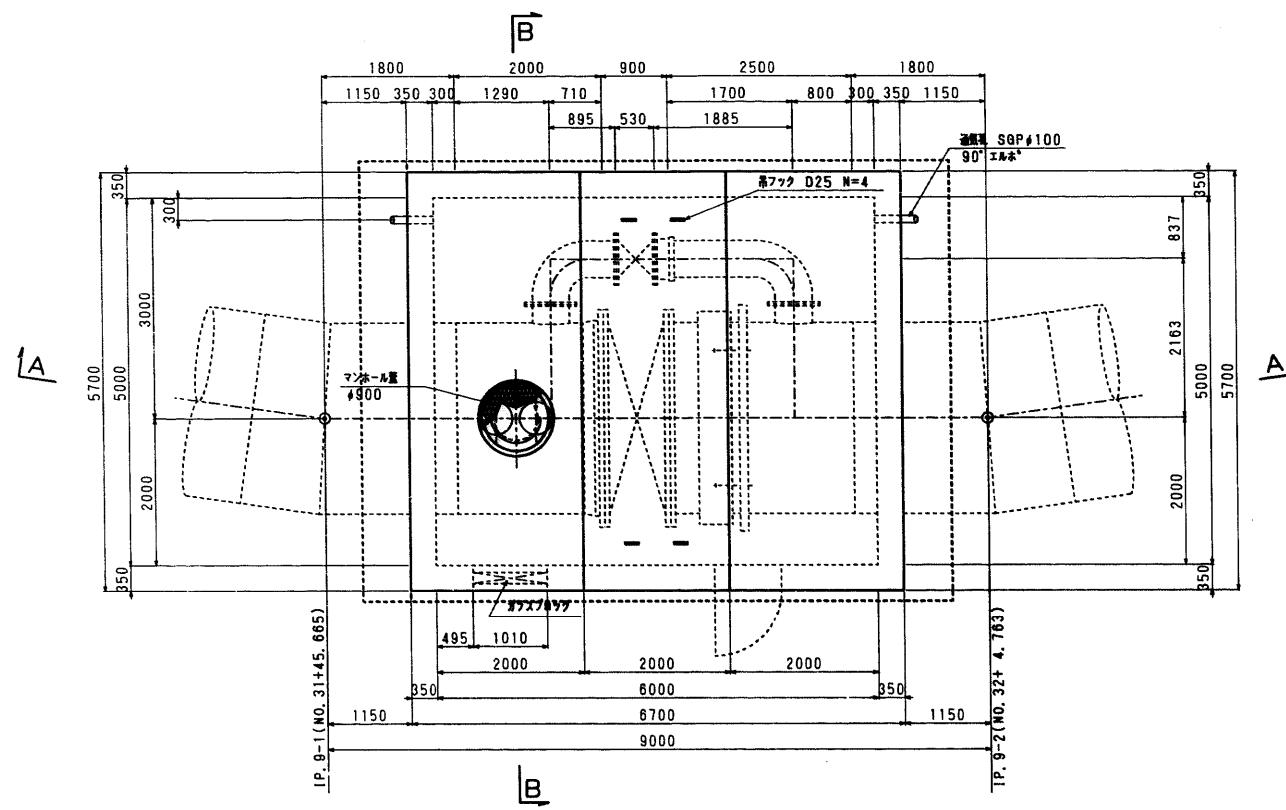


A - A

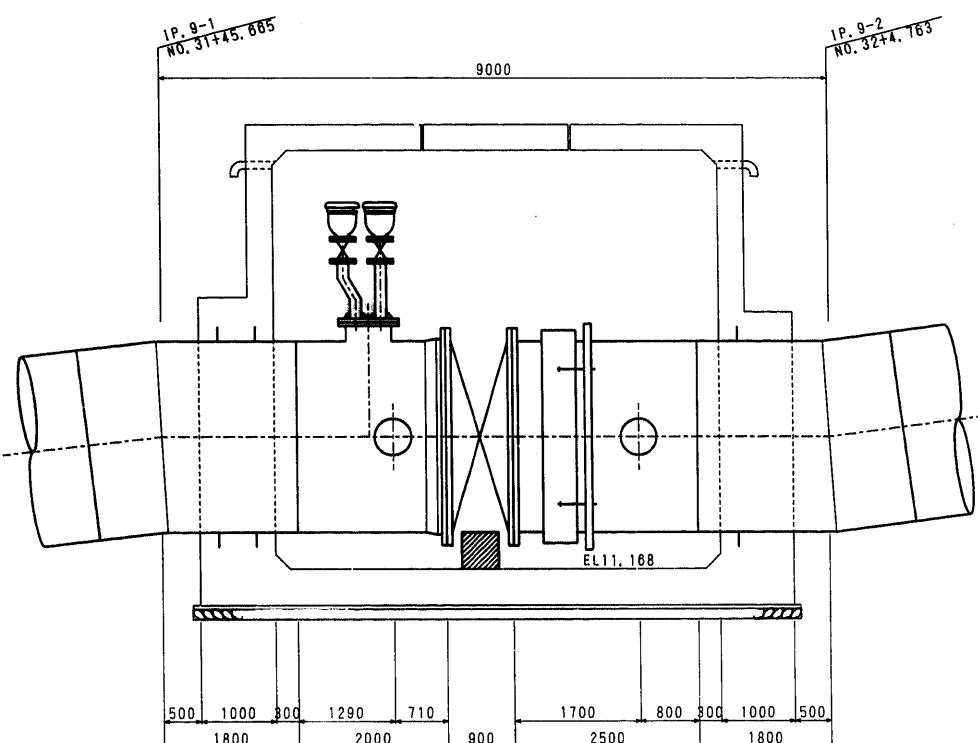

A - A

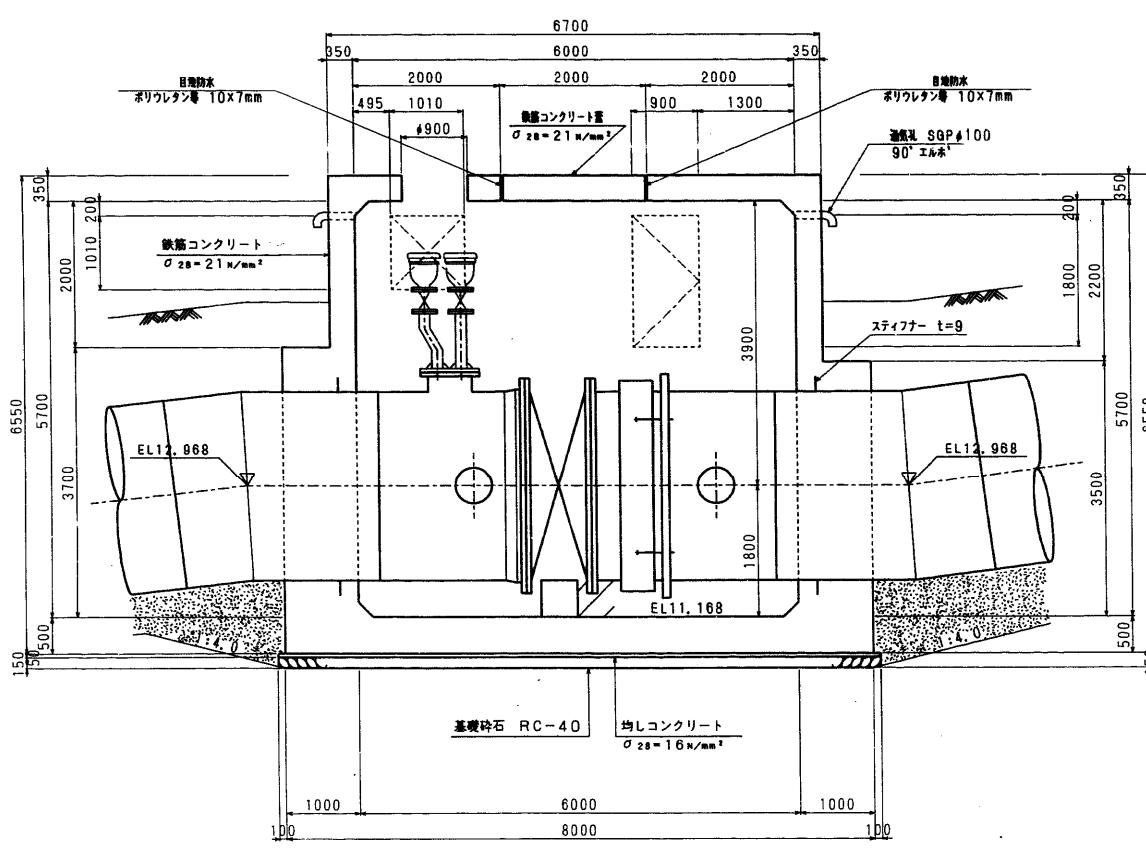

B - B

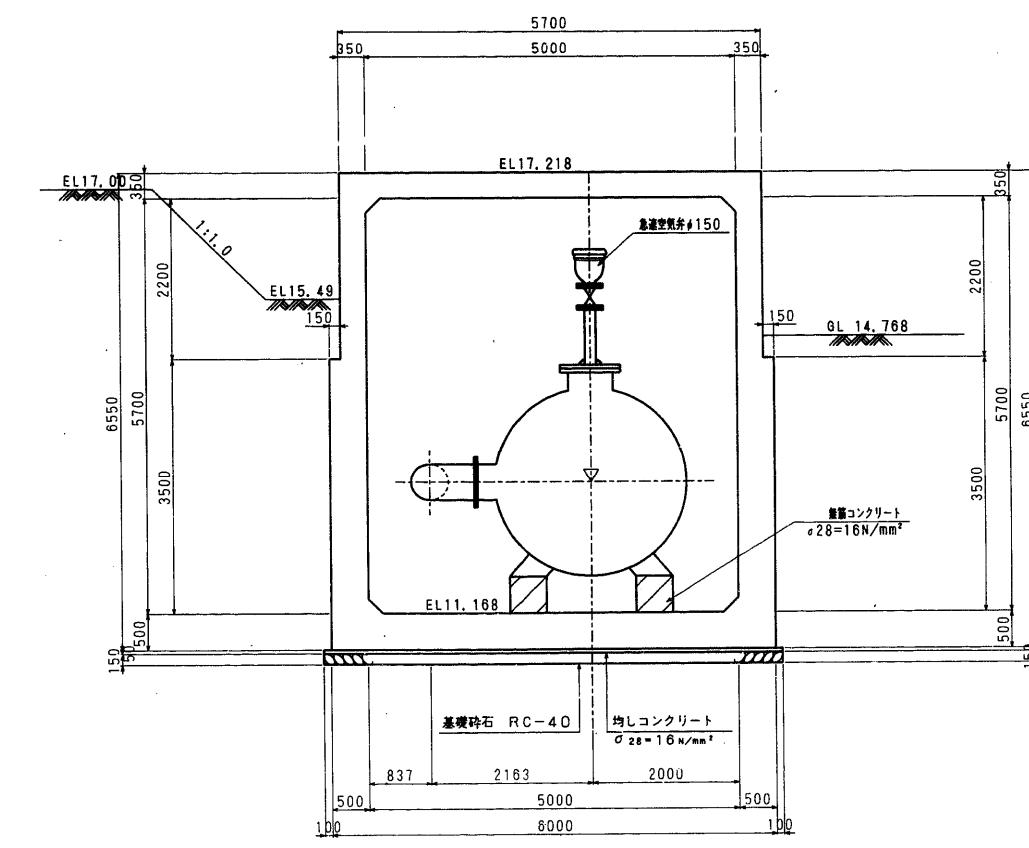


施設名	南部幹線用水路(0312100-1100-20)
図面名	1号制水弁工・9号空気弁工 (1/2)
作成年月	平成26年 3月
縮尺	A1 1:50 A2 1:70
作成者	関東農政局 南総農業水利事業所
	図面番号 8-115/310

1号制水弁工・9号空気弁工 (2/2)


S=1:50

No. 31+49. 915


平面図  
(A - A)

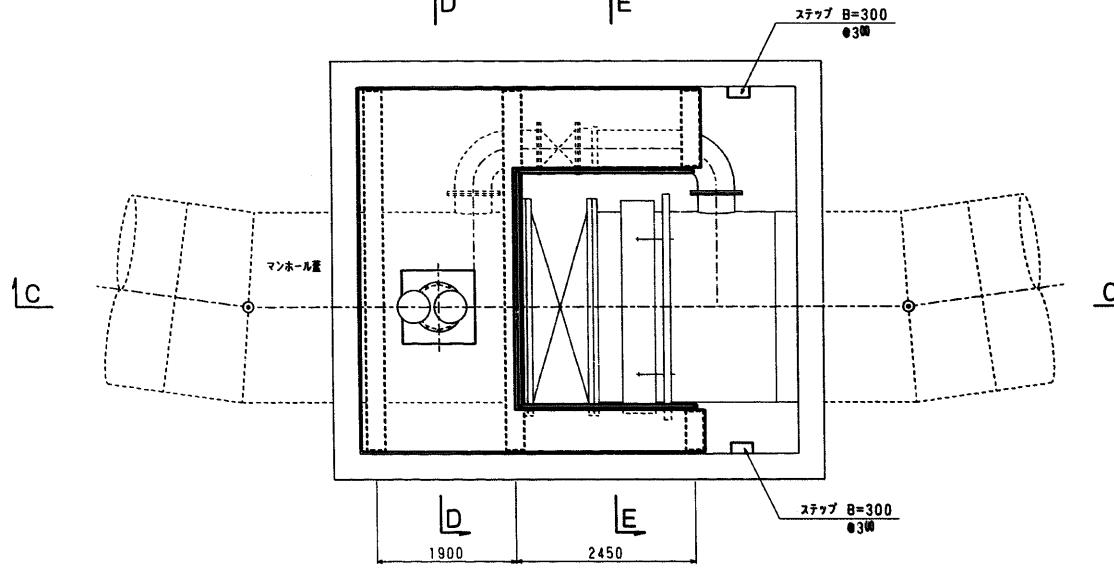


平面図

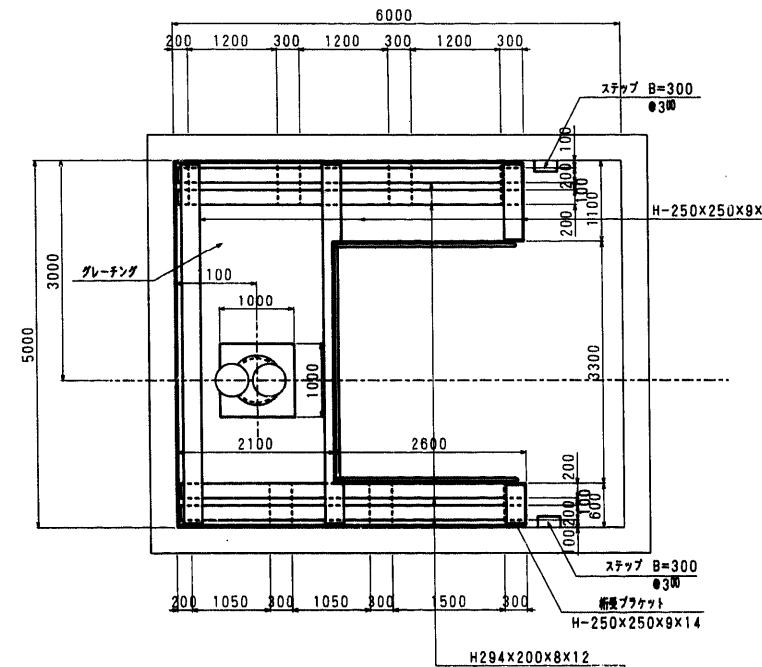


C - C

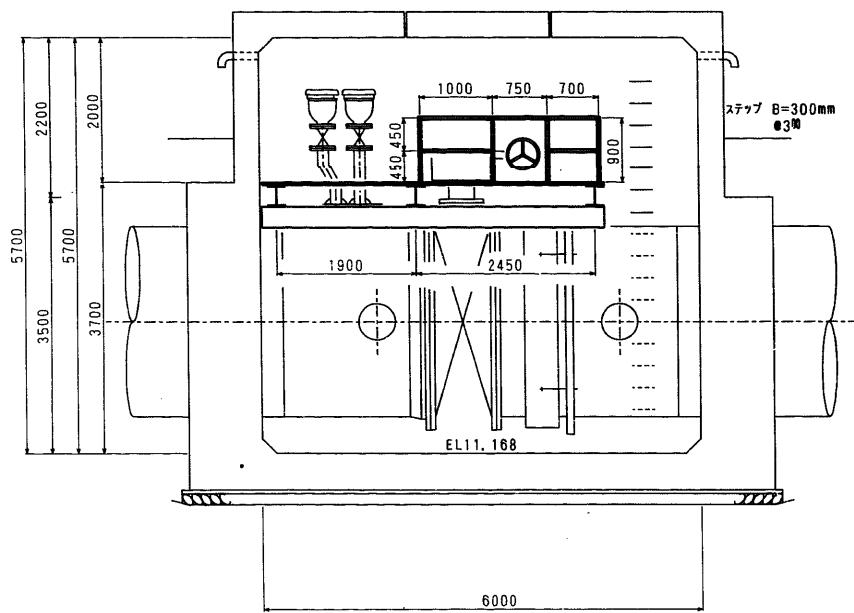

D - D

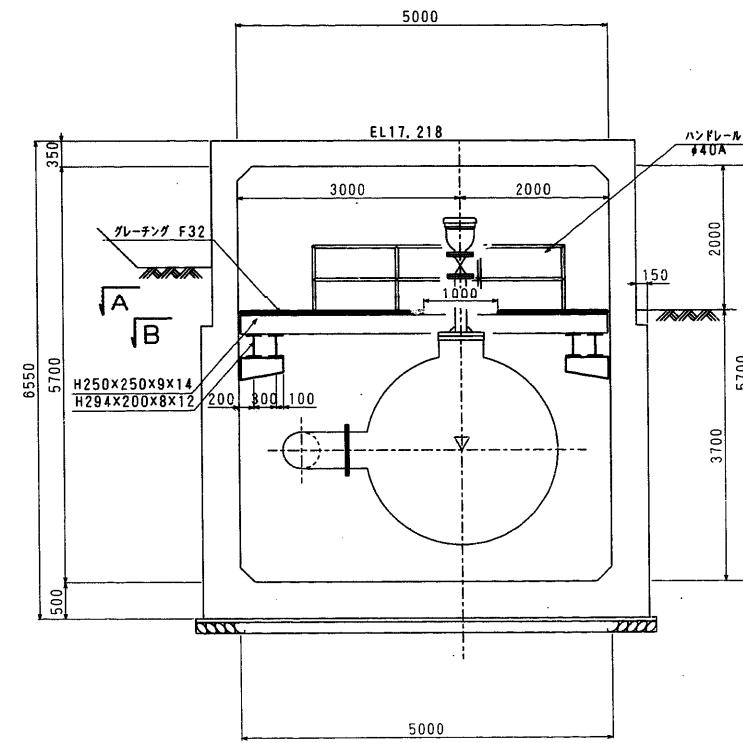

E - E

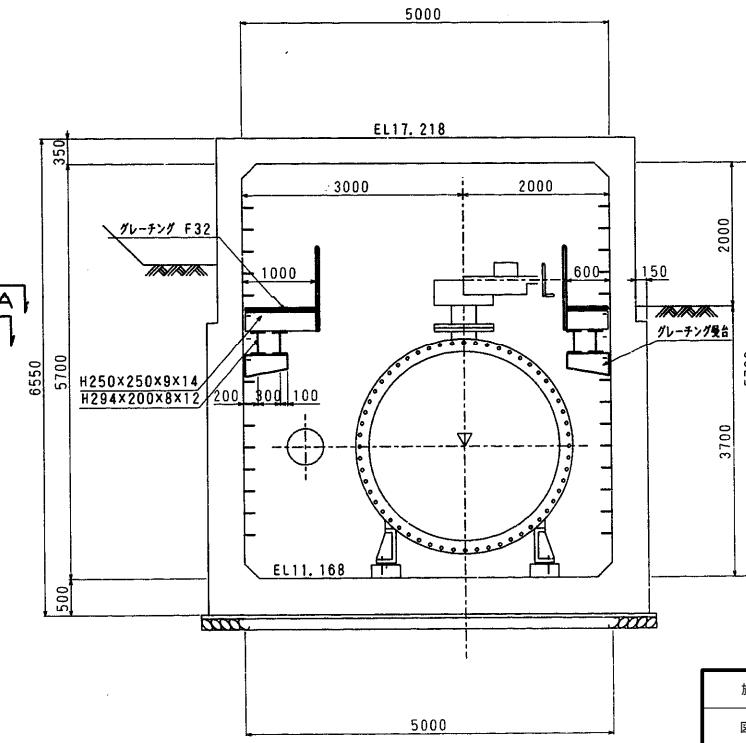

施設名	南部幹線用水路(0312100-1100-20)	
図面名	1号制水弁工・9号空気弁工 (2/2)	
作成年月	平成26年 3月	
縮尺	A1 1:50 A2 1:70	図面番号 8-116/310
作成者	関東農政局 南総農業水利事業所	