



6号制水弁工構造図(1/2)


平面図 S=1:50

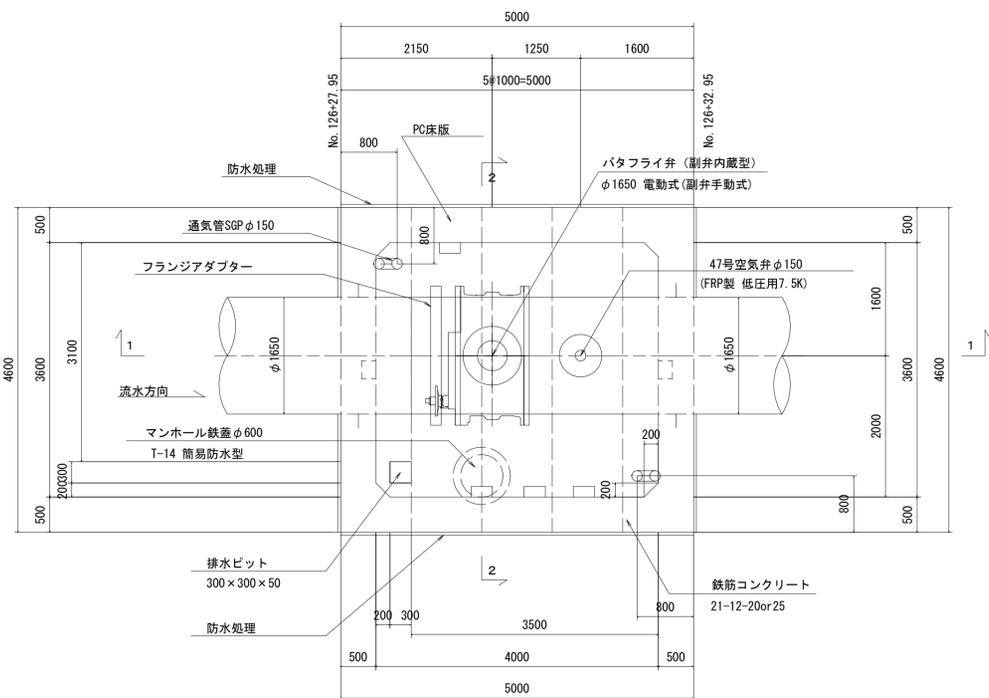


床版平面図 S=1:50

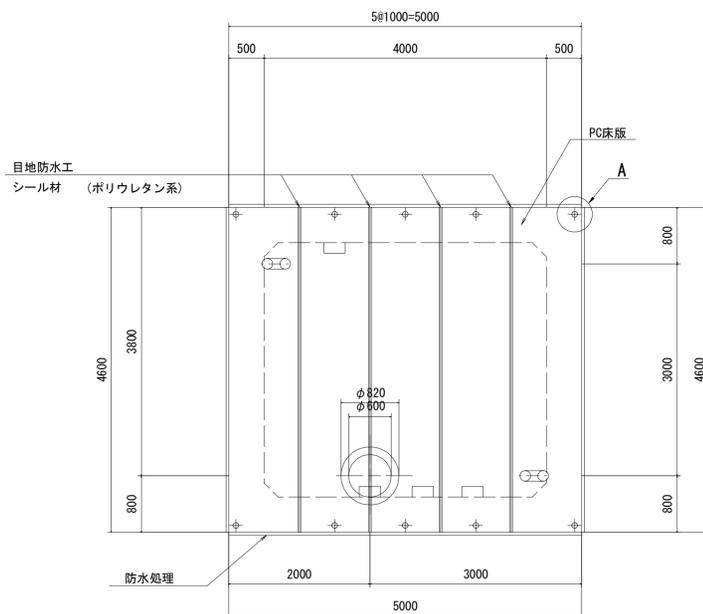


床版断面図 S=1:50

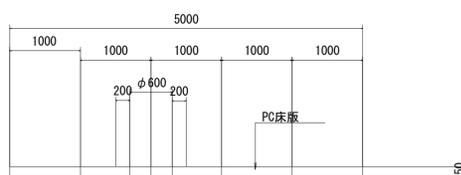


2-2 S=1:50

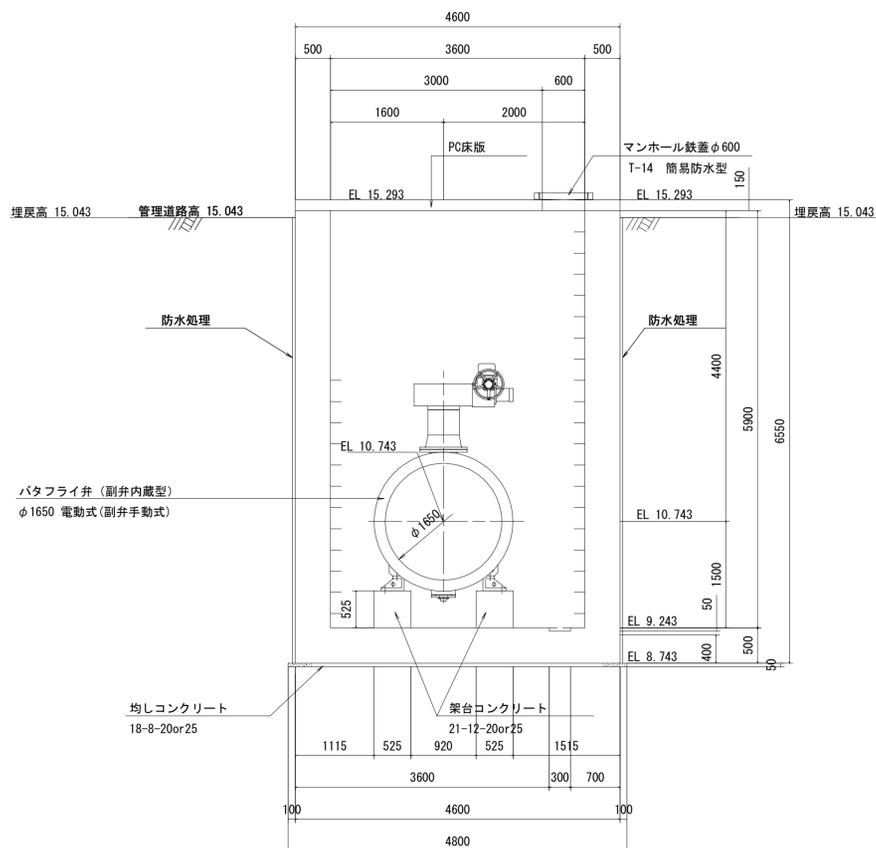


目地防水工詳細図 S=1:20

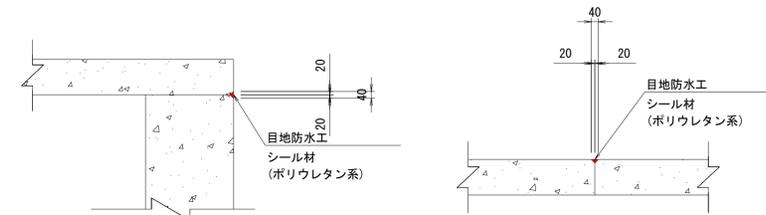


水抜き工詳細図 S=1:20

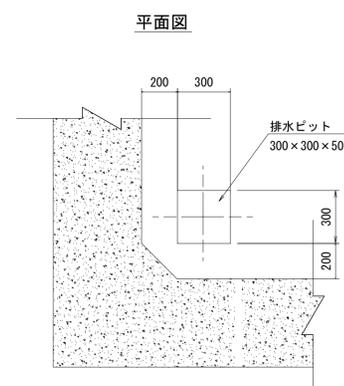


断面図

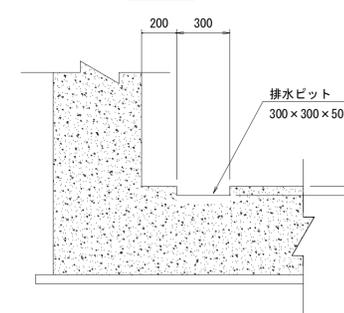


A部詳細 S=1:20

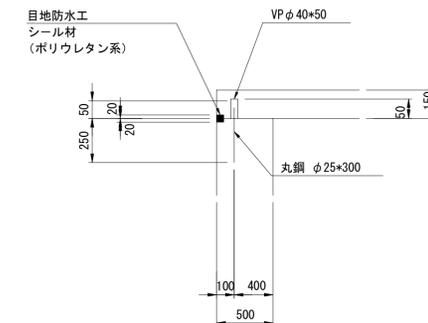


1-1 S=1:50

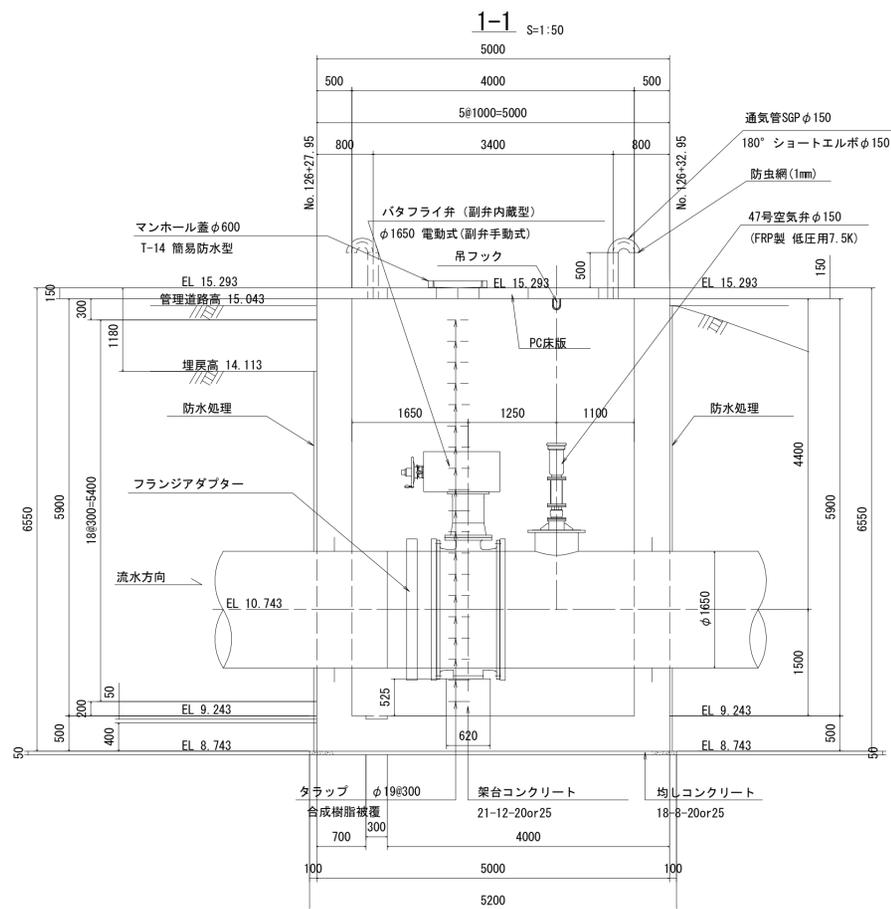

タラップ詳細図 S=1:20

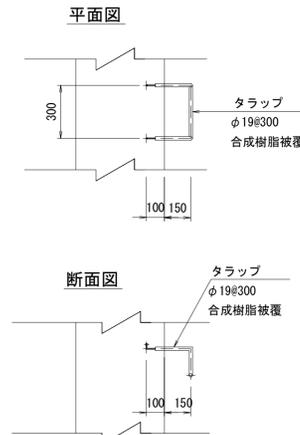

断面図

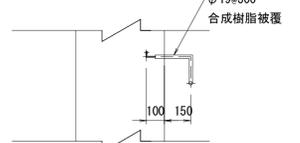

| | | | |
|------|--------------------------|------|-----------|
| 施設名 | 南部幹線用水路(0312100-1100-20) | | |
| 図面名 | 6号制水弁工構造図(1/2) | | |
| 作成年月 | 平成26年 3月 | | |
| 縮尺 | A1 図示 | 図面番号 | 8-132/599 |
| 作成者 | 関東農政局 両総農業水利事業所 | | |

